




THIS DRAWING IS THE PROPERTY OF TMS MECHANICAL SYSTEMS AND IS TO BE RETURNED UPON REQUEST. IT CONTAINS CONFIDENTIAL INFORMATION WHICH MUST NOT BE DISCLOSED TO ANYONE OR USED FOR CONSTRUCTION WITHOUT WRITTEN CONSENT. IT IS PROVIDED WITH THE EXPRESS UNDERSTANDING THAT THE DRAWING AND INFORMATION THEREON WILL NOT BE USED IN WHOLE OR IN PART TO REPRODUCE OR TO FORMERLY REPRODUCE FOR THE PURPOSE OF REPRODUCING, PRINTING, OR OTHER REPRODUCING THEREOF OR ANY PARTS THEREOF, OR FOR ANY OTHER PURPOSE WITHOUT THE WRITTEN CONSENT OF THE ACCEPTANCE OF THIS DRAWING CONSTITUTES ACCEPTANCE OF THE FOREGOING AGREEMENT.

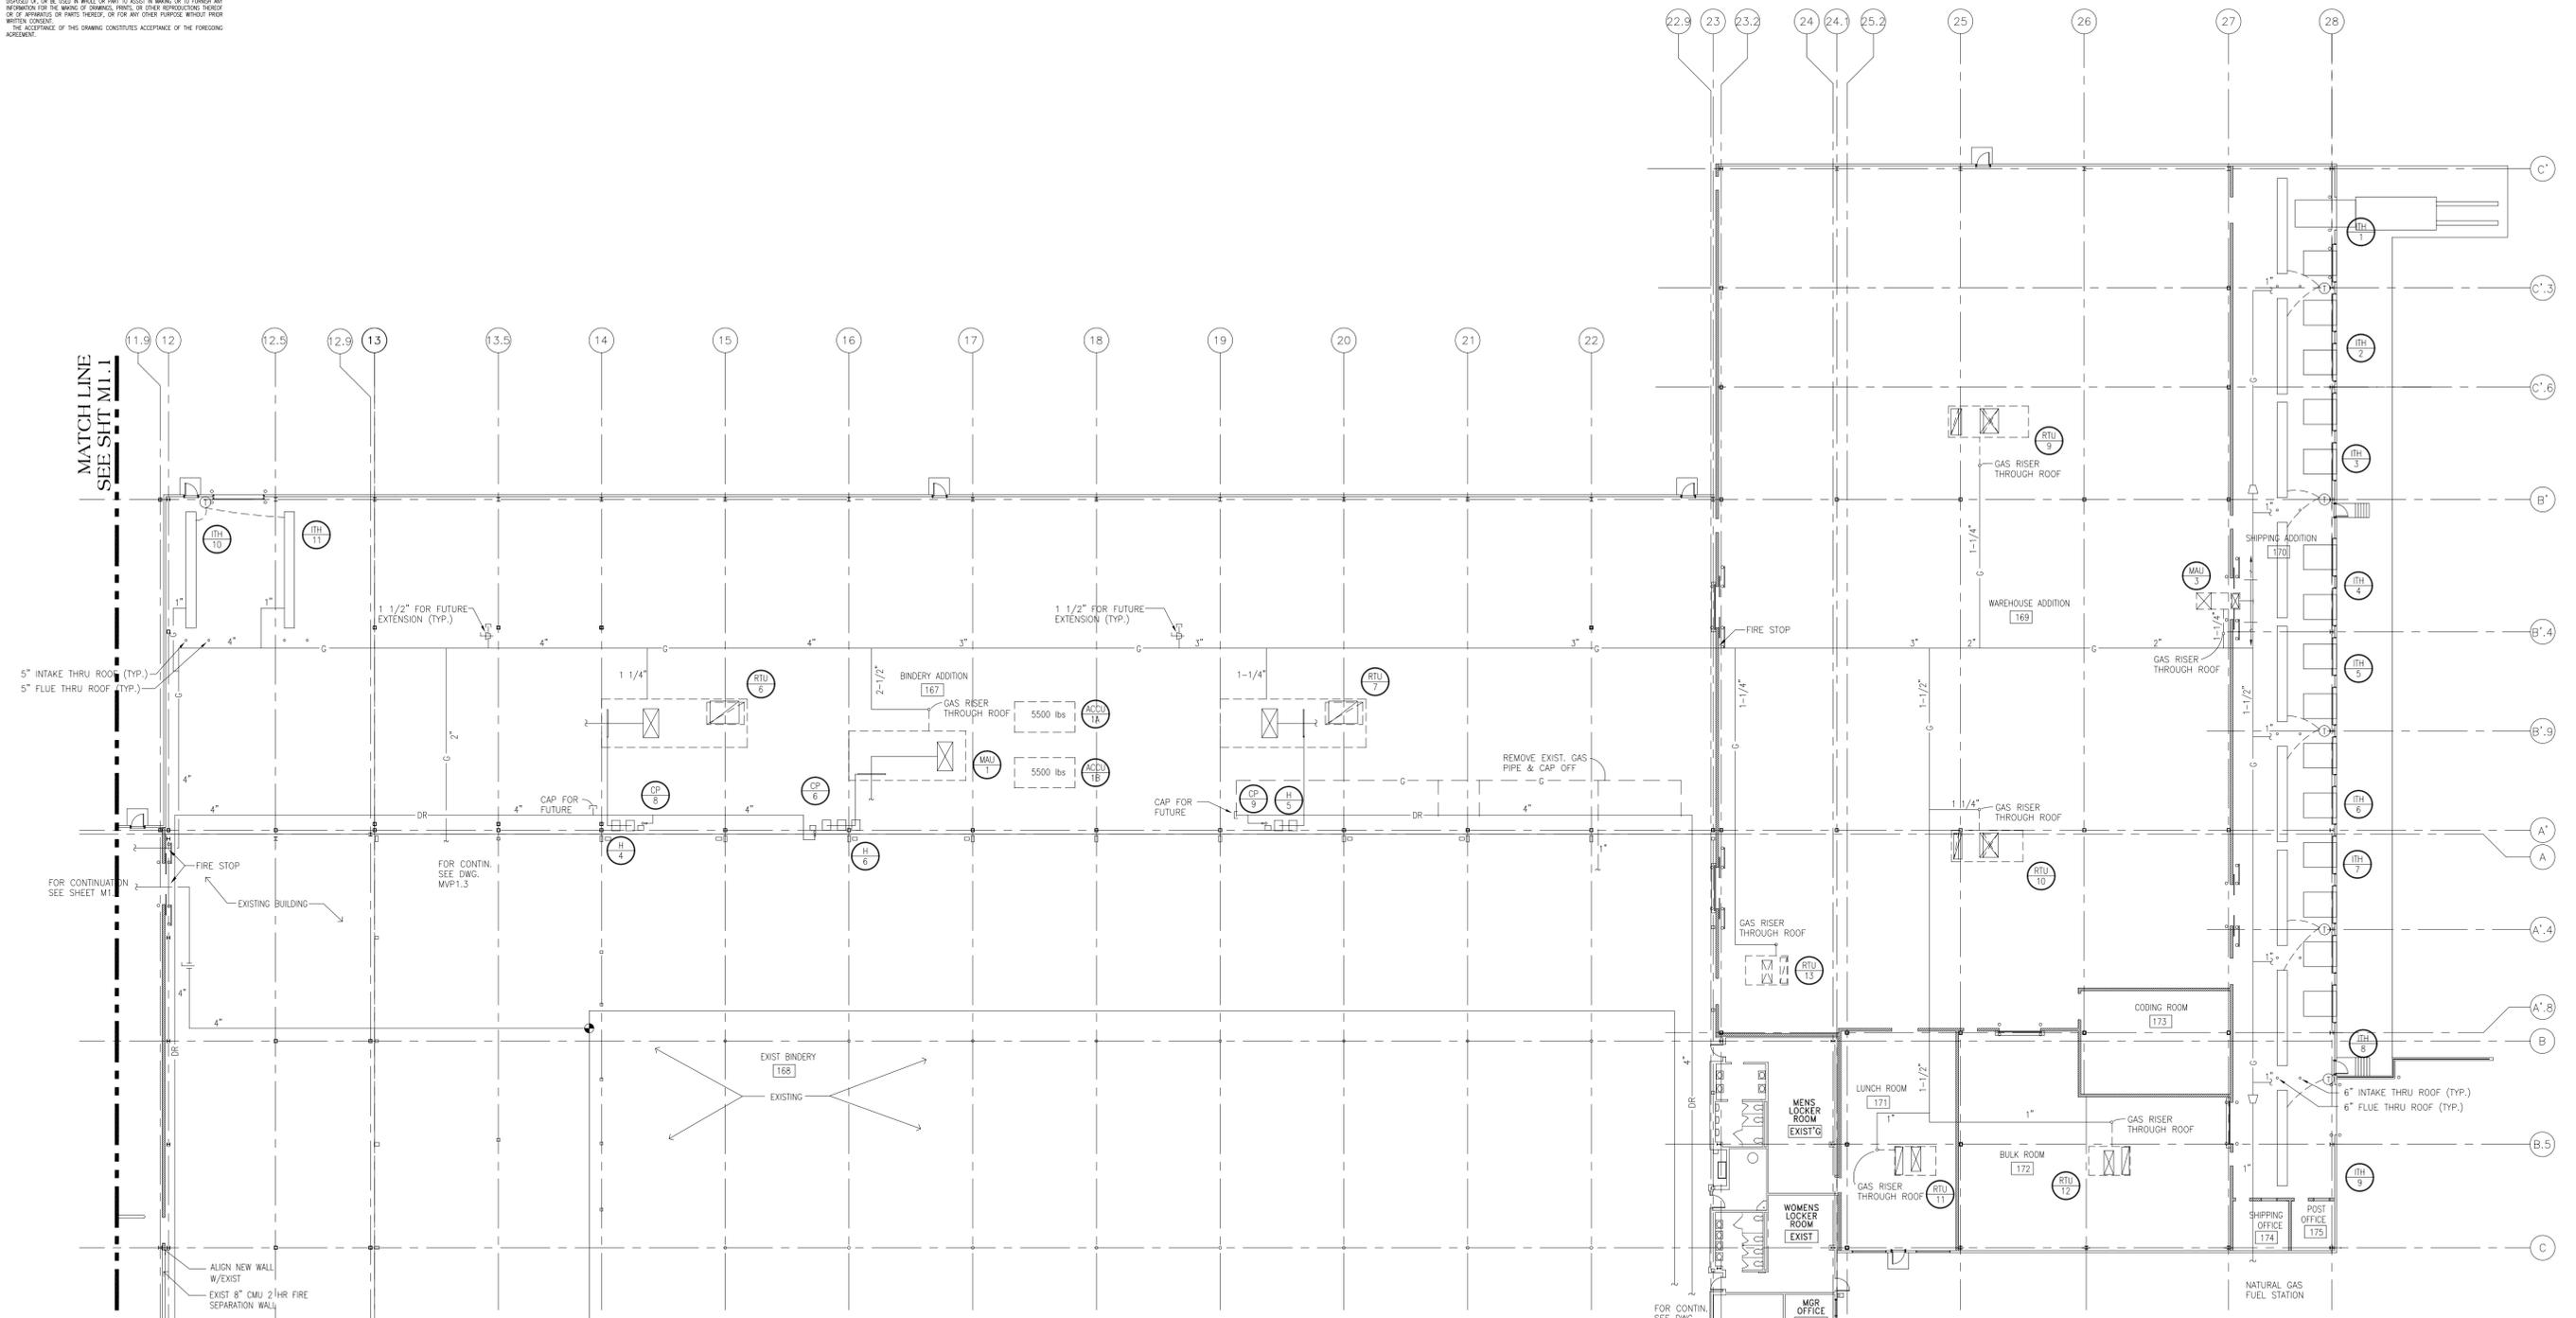


PARTIAL MECHANICAL FLOOR PLAN—SOUTH SECTION  
SCALE: 1/16" = 1' - 0"

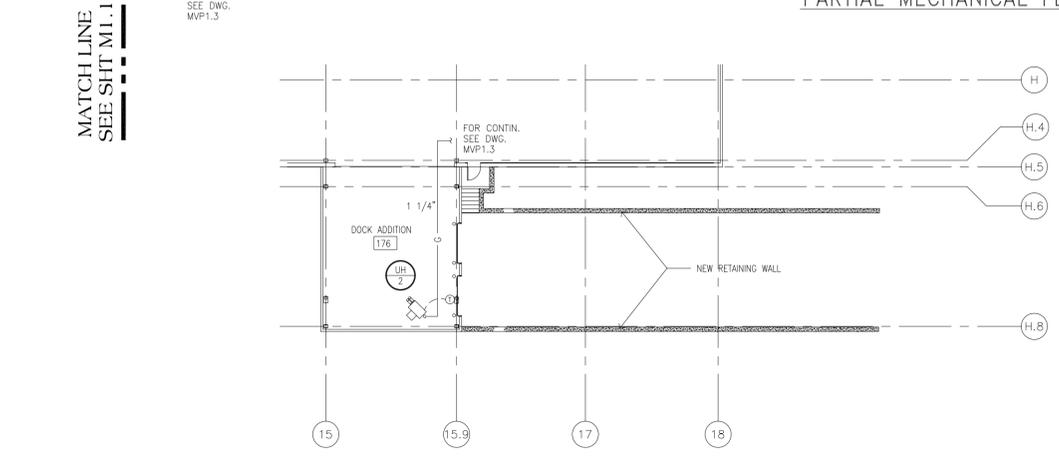

PARTIAL FLOOR PLAN OF DOCK ADDITION  
SCALE: 1/16" = 1' - 0"

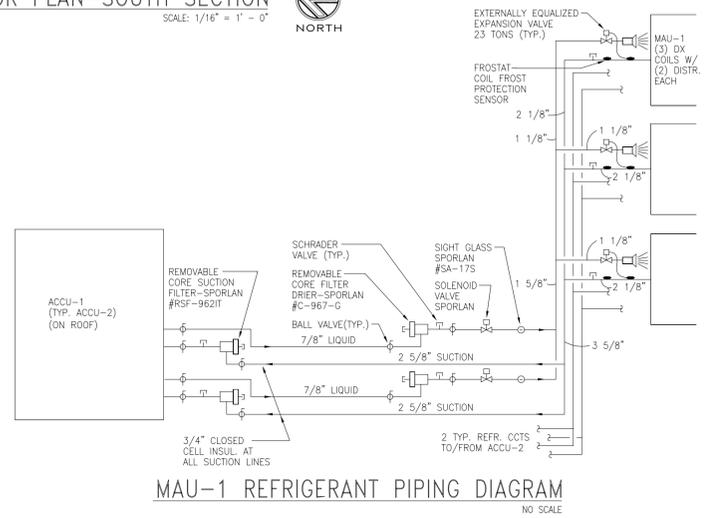

MAU-1 REFRIGERANT PIPING DIAGRAM  
NO SCALE

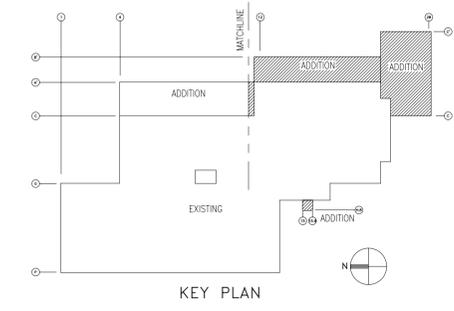

ATTENTION  
This drawing is PRELIMINARY and is not intended for construction.

9-13-00	ISSUED FOR BIDDING & PERMITS	
4-14-00	ISSUED FOR BIDDING	
4-14-00	ISSUED FOR OWNER'S REVIEW	
REV.	DATE	DESCRIPTION
MECHANICAL PLAN - SOUTH		
<b>tms</b> PLANNERS DESIGNERS ENGINEERS		
2101 Hammond Drive Schaumburg, Illinois 60173 Phone: 847-397-2100 Fax: 847-397-8980		
<b>BROWN PRINTING</b> PRESS ROOM, BINDERY AND WAREHOUSE EXPANSION		
11595 MCCONNELL ROAD WOODSTOCK, ILLINOIS		
DWN. BY	SCALE 1/16" = 1'-0"	DWG. NO.
APP. BY	JOB NO. 6518/6523	M1.2
CKD. BY	DATE 4/13/00	